

FIRE ALARM SYSTEM SUPERVISION			
ZONE	ALARM	ALERT/TROUBLE ONLY	
ATTIC	- FLOW SWITCH (DRY)	- CONTROL VALVE (DRY), AIR PRESSURE (DRY). LOW ROOM TEMPERATURE	
THIRD FLOOR	- PULL STATION, SMOKE DETECTOR - FLOW SWITCH (WET)	- CONTROL VALVE (WET)	
SECOND FLOOR	- PULL STATION, SMOKE DETECTOR - FLOW SWITCH (WET)	- CONTROL VALVE (WET)	
GROUND FLOOR	- PULL STATION, SMOKE DETECTOR - FLOW SWITCH (WET)	- CONTROL VALVE (WET)	
BASEMENT	- PULL STATION, SMOKE DETECTOR		
ELEVATOR	- SMOKE DETECTOR	-GENERAL TROUBLE	
STAIR 001	- SMOKE DETECTOR		
STAIR 007	- SMOKE DETECTOR		
EAST STAIR 152	- SMOKE DETECTOR		
WEST STAIR 139	- SMOKE DETECTOR		
MAIN WATER ENTRANCE (BASEMENT)	- MAIN FLOW SWITCH (WET)	- MAIN CONTROL VALVE (WATER ENTRANCE) - BACKFLOW VALVE x2 - MAIN CONTROL VALVE (WET)	

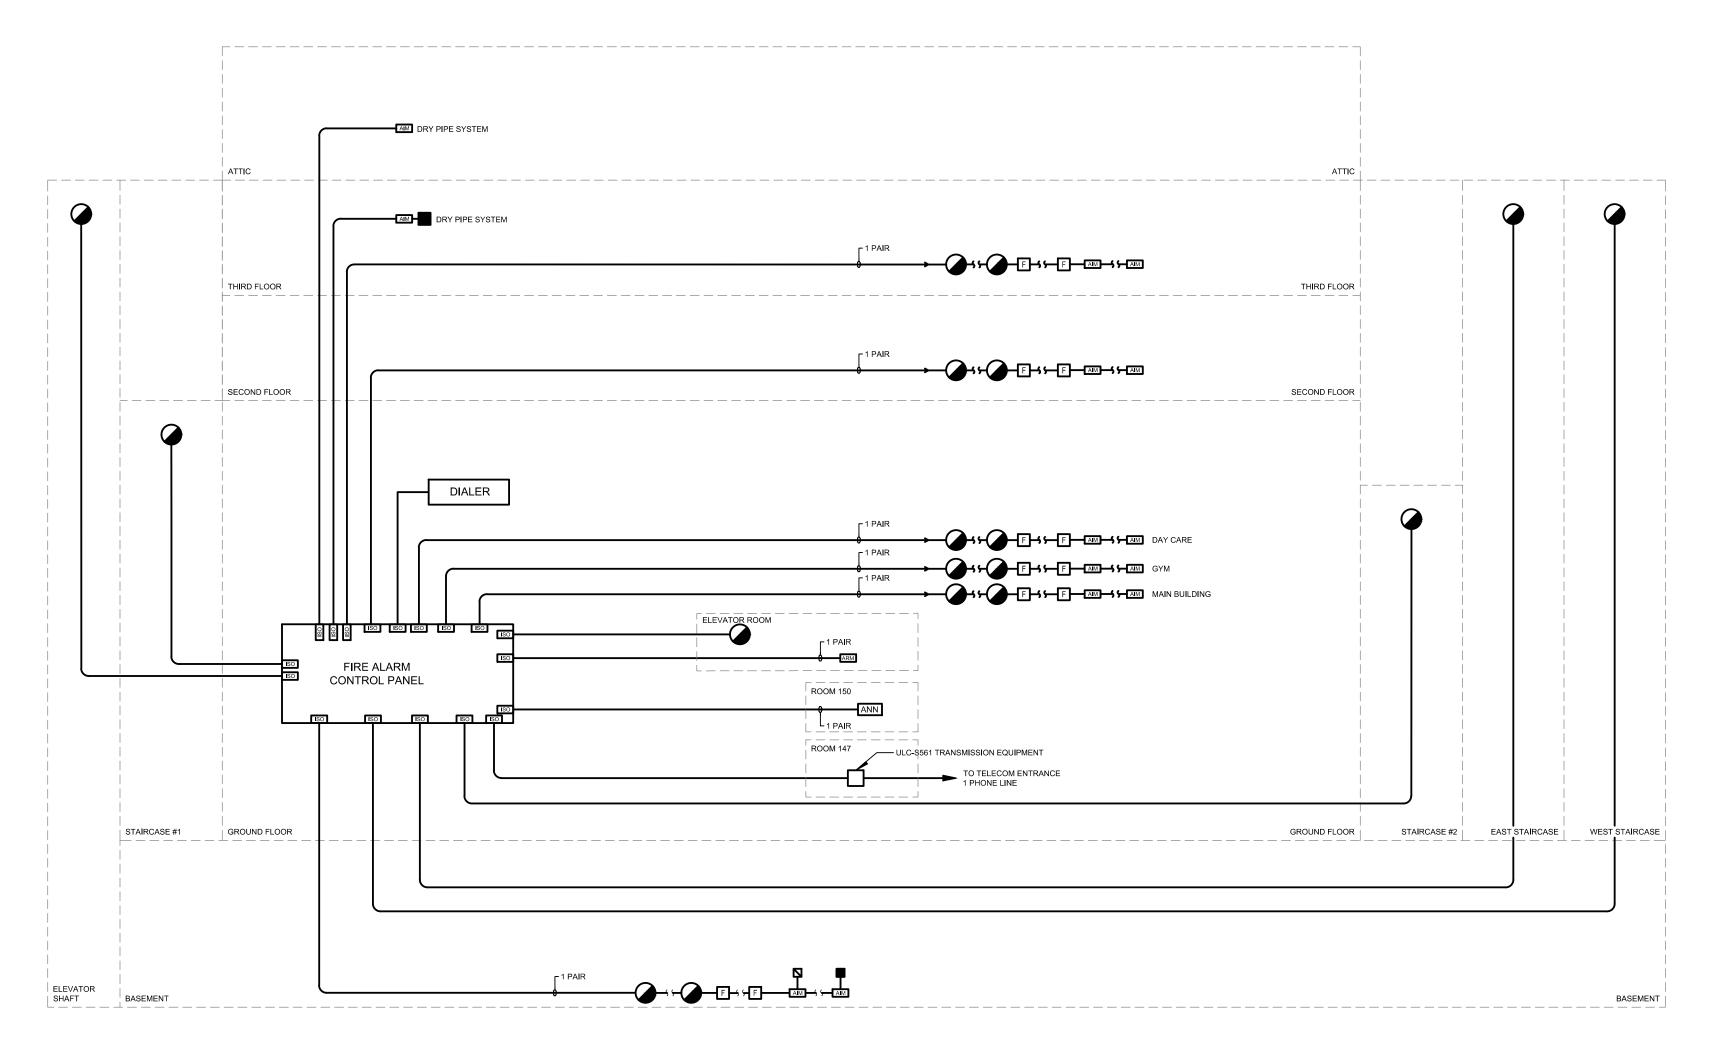

1 FIRE ALARM SINGLE LINE DIAGRAM (DETECTION) SCALE: N.T.S.

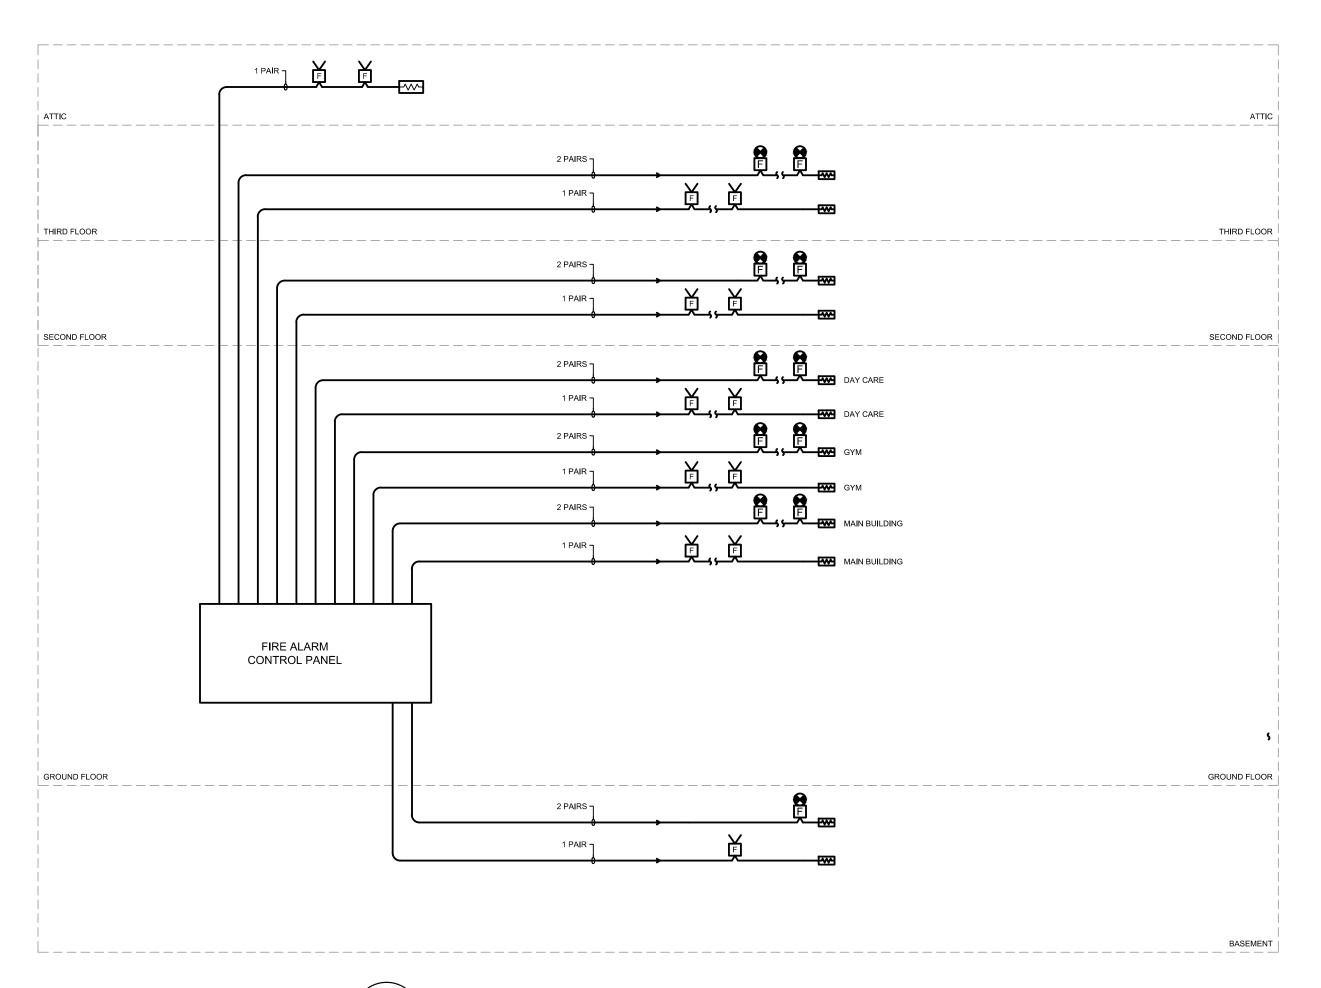

2 FIRE ALARM SINGLE LINE DIAGRAM (SIGNALISATION)


SCALE: N.T.S.

GENERAL NOTE(S):

- 1- REFER TO DRAWINGS FOR EXACT LOCATION AND INSTALLATION DETAILS OF FIRE ALARM DEVICES.
- 2- THE FIRE ALARM SINGLE LINE DIAGRAM (DETECTION) ONLY SHOWS GENERAL INTENT AND INTERACTION BETWEEN THE FIRE ALARM PANEL, DEVICES, INPUTS. IT DOES NOT PROVIDE QUANTITIES AND PROPER WIRING METHOD. THE CONTRACTOR IS RESPONSIBLE FOR PROVIDING A COMPLETE SYSTEM THAT OPERATES AS DESCRIBED

IN THE SPECIFICATIONS AND AS PER CODE REQUIREMENTS.


3- THE FIRE ALARM SINGLE LINE DIAGRAM (SIGNALISATION) ONLY SHOWS GENERAL INTENT AND INTERACTION BETWEEN THE FIRE ALARM PANEL, DEVICES, INPUTS. IT DOES NOT PROVIDE QUANTITIES AND PROPER WIRING METHOD. THE CONTRACTOR IS RESPONSIBLE FOR PROVIDING A COMPLETE SYSTEM THAT OPERATES AS DESCRIBED IN THE SPECIFICATIONS AND AS PER CODE REQUIREMENTS.

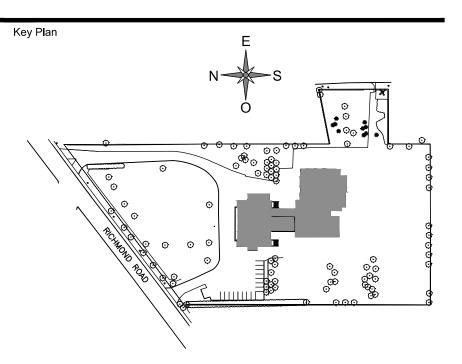

Nº	Date		Description
0	2018-06-01	FOR TENDER	



Structure

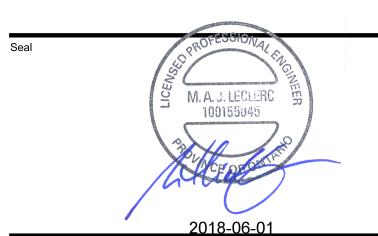

ct

MAISON DE DE LA FRANCOPHONIE D'OTTAWA

2720 RICHMOND ROAD, OTTAWA

ELECTRICAL FIRE ALARM SINGLE LINE DISTRIBUTION

THIS DRAWING SHALL NOT BE USED FOR CONSTRUCTION OR INSTALLATION

Design by: J.RI.

Verified by: M.LE.

PURPOSES.

Drawing n°

E-011

O